

DO NOT SCALE FROM THIS DRAWING. USE FIGURED DIMENSIONS IN ALL CASES.
VERIFY DIMENSIONS ON SITE AND REPORT ANY DISCREPANCIES TO THE
DESIGNERS IMMEDIATELY.
THIS DRAWING TO BE READ IN CONJUNCTION WITH THE DESIGNERS
SPECIFICATION.
© THIS DRAWING IS COPYRIGHT AND MAY ONLY BE REPRODUCED WITH THE
DESIGNERS PERMISSION.

NOTES:

- ALL DRAWINGS ARE TO BE READ IN CONJUNCTION WITH ALL RELEVANT SPECIFICATIONS, BILLS OF QUANTITIES, ARCHITECTURAL, SERVICES AND ENGINEERING DRAWINGS.
- ALL LEVELS ARE IN METRES RELATED TO ORDNANCE DATUM MALIN HEAD.
- ANY DISCREPANCIES BETWEEN THESE DOCUMENTS SHALL BE BROUGHT TO THE ATTENTION OF THE ENGINEER.
- DRAWINGS ARE NOT TO BE SCALED.
- ALL DIMENSIONS ARE IN MILLIMETRES, UNLESS NOTED OTHERWISE.

MPG-IN 20W CANARIAS
Article No.: MPG-IN 20W CANARIAS
Luminous flux (Luminaire): 1738 lm
Luminous flux (Lamps): 2786 lm
Luminaire Wattage: 20.0 W
Luminaire classification according to CIE: 100
CIE flux code: 51 87 99 100 62
Fitting: 1 x User defined (Correction Factor 1.000)




MPG-IN 30W CANARIAS
Article No.: MPG-IN 30W CANARIAS
Luminous flux (Luminaire): 2607 lm
Luminous flux (Lamps): 3919 lm
Luminaire Wattage: 30.0 W
Luminaire classification according to CIE: 100
CIE flux code: 51 87 99 100 62
Fitting: 1 x User defined (Correction Factor 1.000)



MPG-IN 40W CANARIAS
Article No.: MPG-IN 40W CANARIAS
Luminous flux (Luminaire): 3494 lm
Luminous flux (Lamps): 5391 lm
Luminaire Wattage: 40.0 W
Luminaire classification according to CIE: 100
CIE flux code: 51 87 99 100 62
Fitting: 1 x User defined (Correction Factor 1.000)





ALL LIGHTING FIXTURES C/W PHOTOCELL TO BE
MOUNTED ON 6 METER HEXAGONAL GALVANISED
STEEL COLUMNS

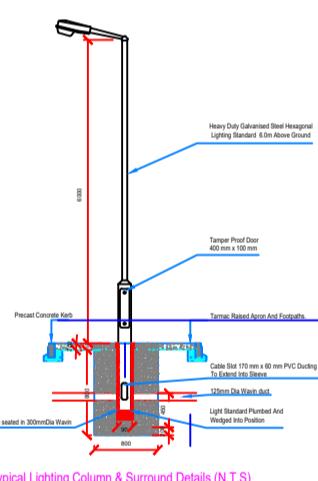

NORTH OF SITE

SCALE 1:500

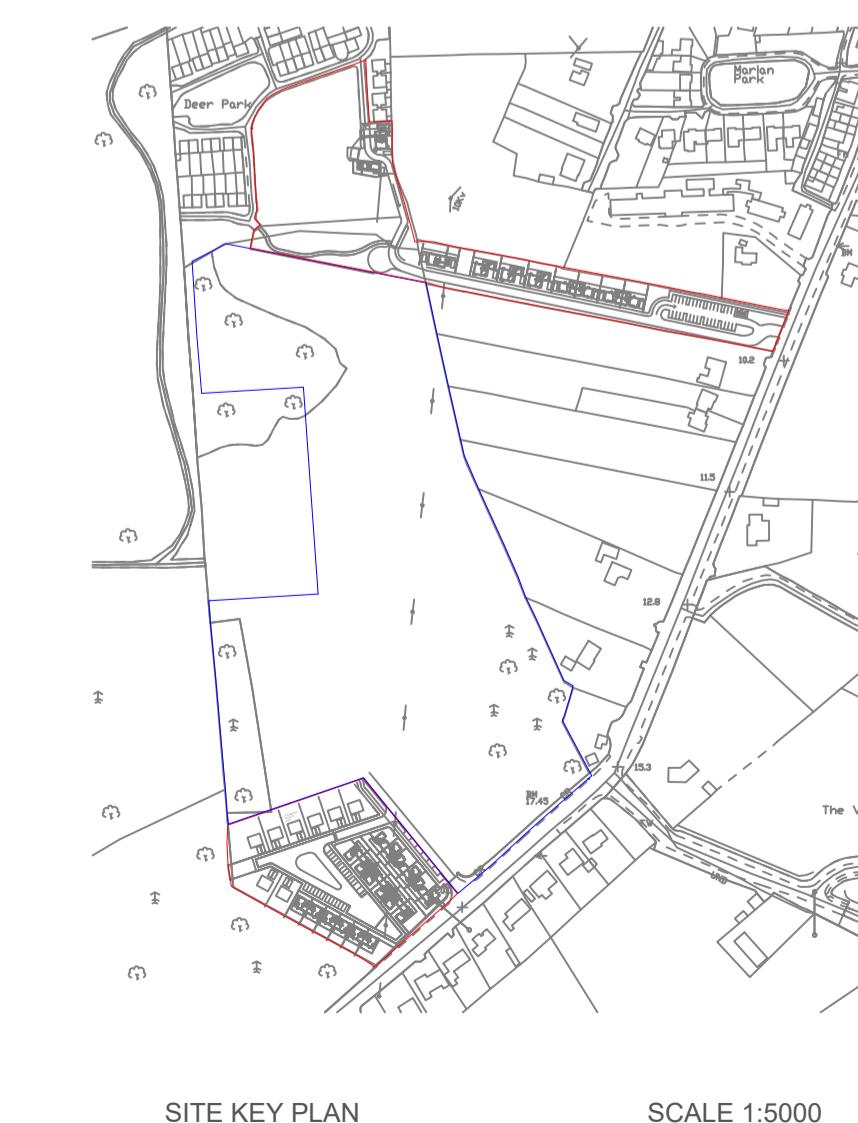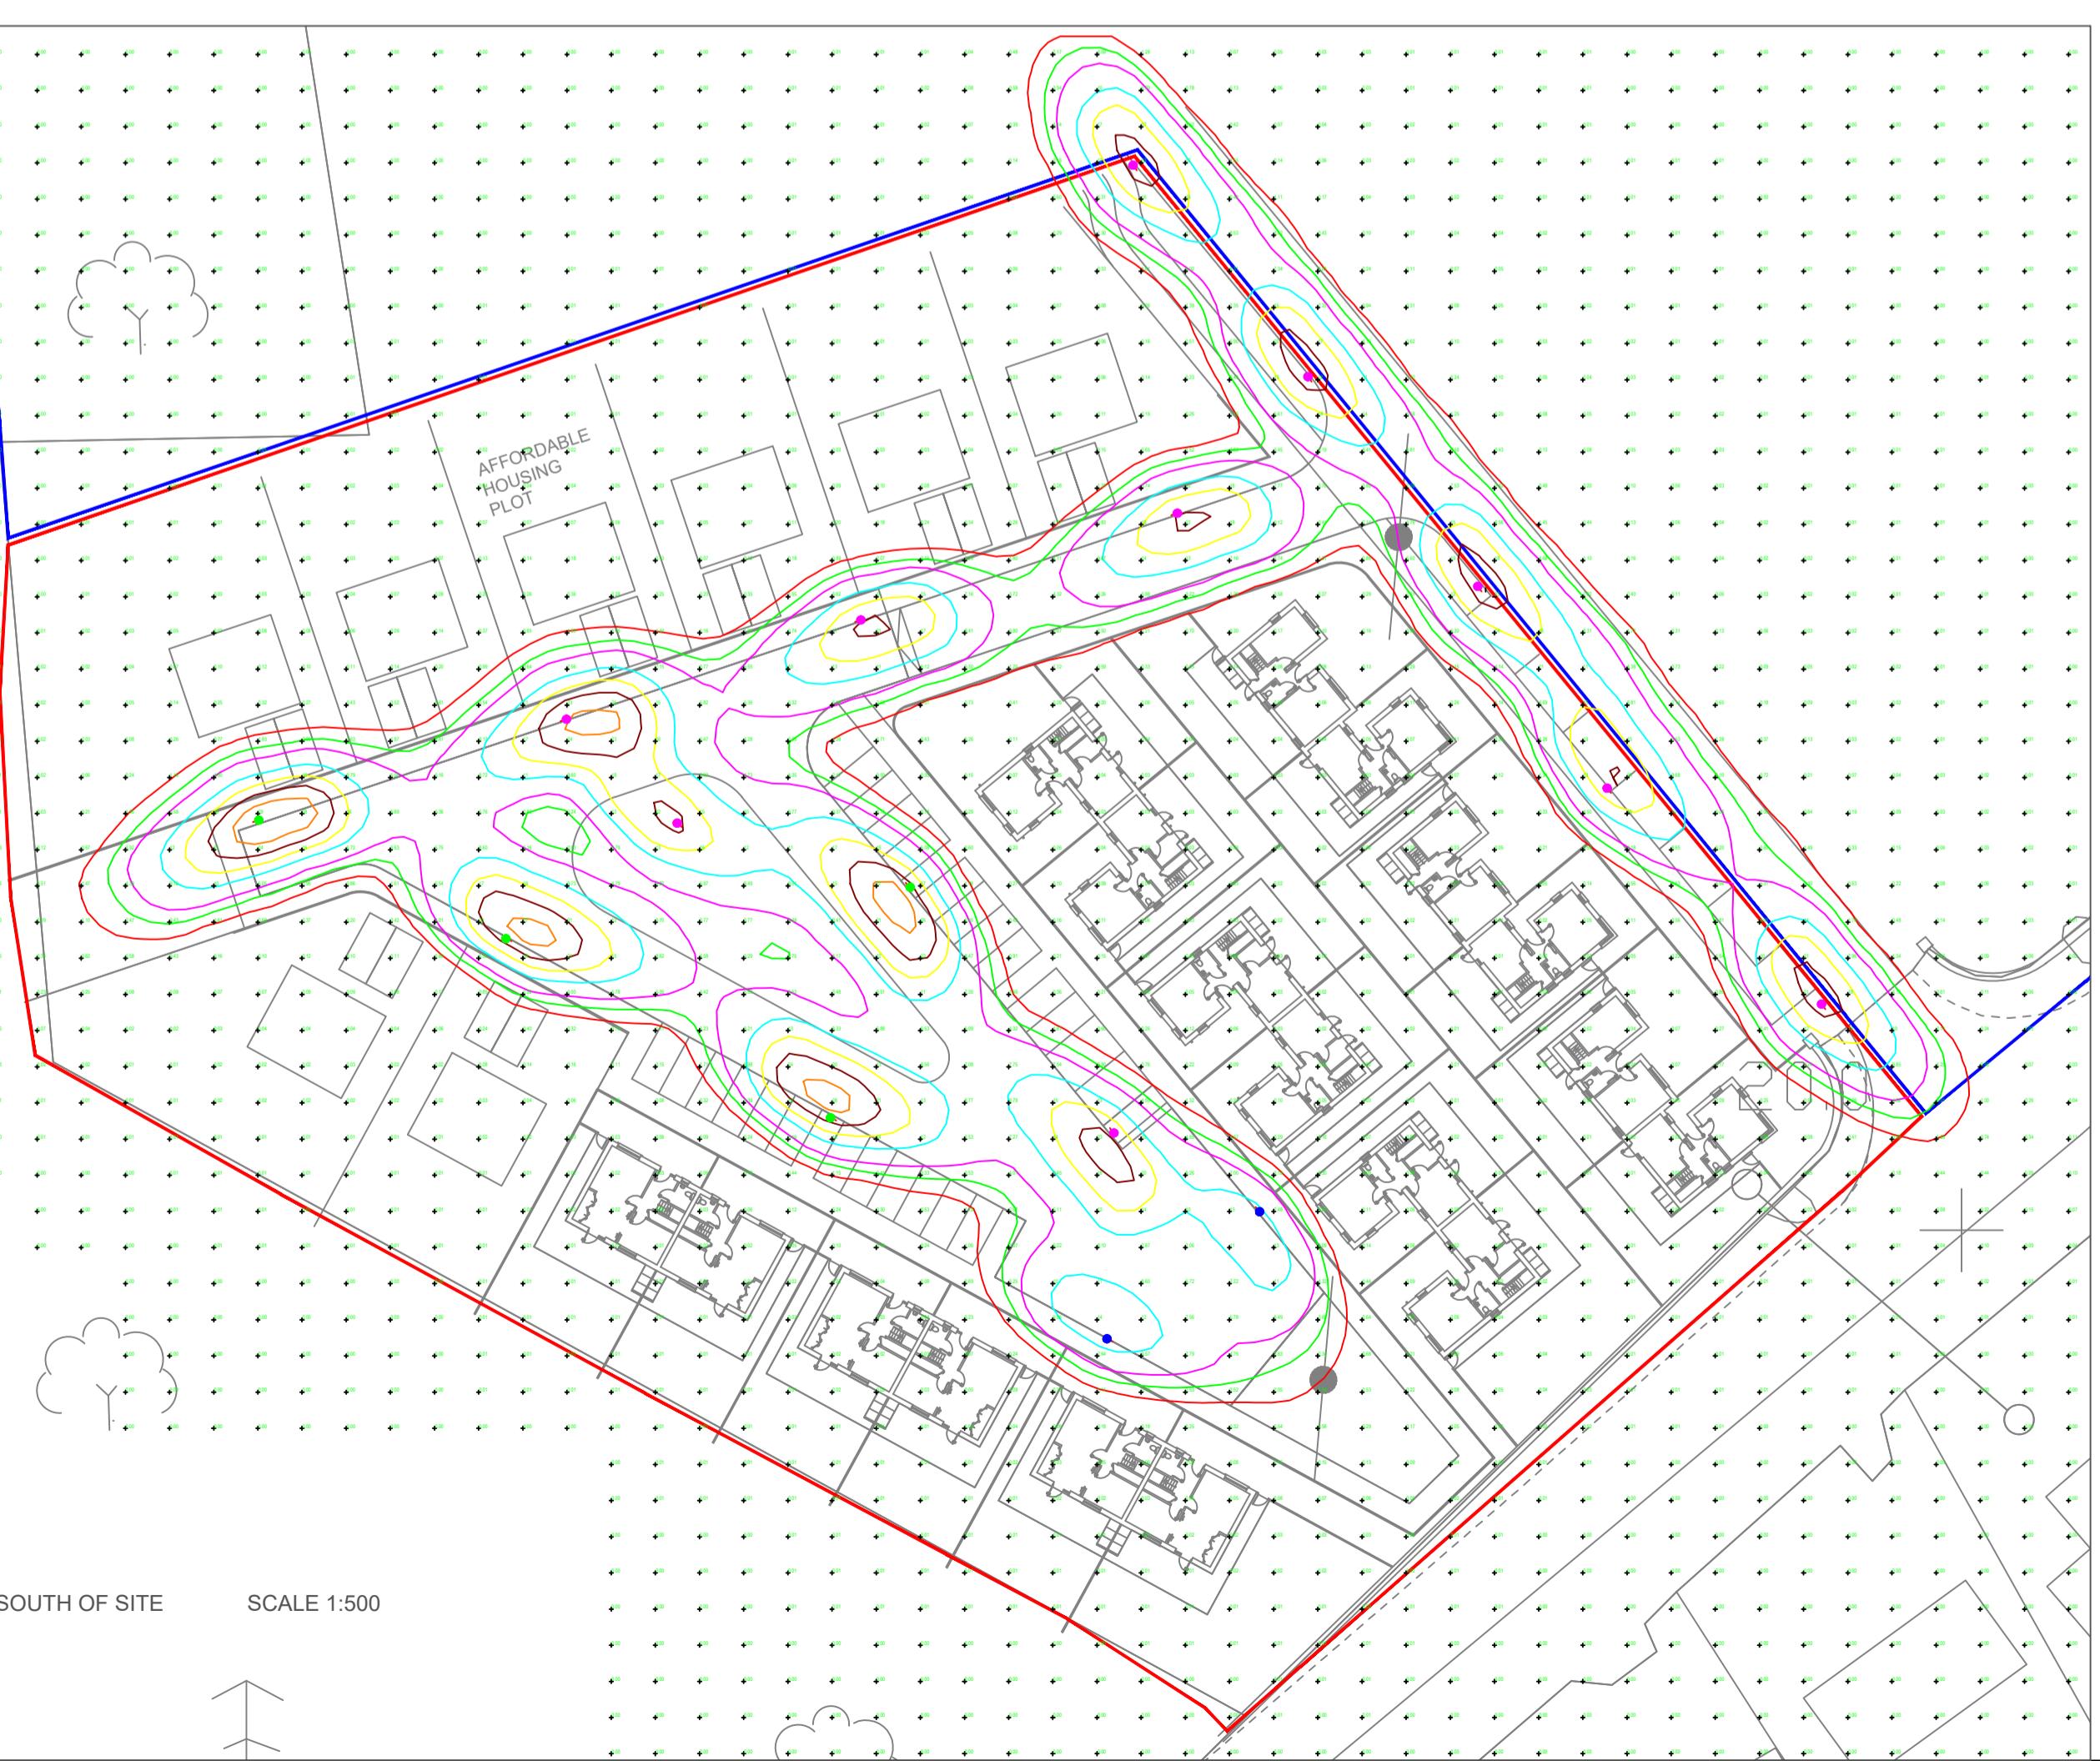

B	17/10/2019	ISSUED FOR PLANNING	JS	DA	
A	15/10/2019	ISSUED FOR PLANNING	JS	DA	
REV	DATE	DESCRIPTION			

PROJECT: RESIDENTIAL DEVELOPMENT DEERPARK, ADARE, Co. LIMERICK

TITLE: SITE LIGHTING LAYOUT

CLIENT: LIMERICK CITY AND COUNTY COUNCIL

Malachy Walsh and Partners
Engineering and Environmental Consultants
Cork | Tralee | London | Limerick

The Elm Suite,
Loughmore Centre,
Raheen Business Park,
Limerick,
V94 R578
Tel: +353 (0) 61 480164
Fax: +353 (0) 61 441125
E-mail: limerick@mwp.ie
Web: www.mwp.ie

DRAWN: JS CHECKED: FF APPROVED: DA

DATE: 15/10/2019 SCALE @ A1: 1: 500

PROJECT NUMBER: 20734 DRAWING STATUS: S2

DRAWING NUMBER: 20734-MWP-00-ZZ-DR-E-9100 REV: B